


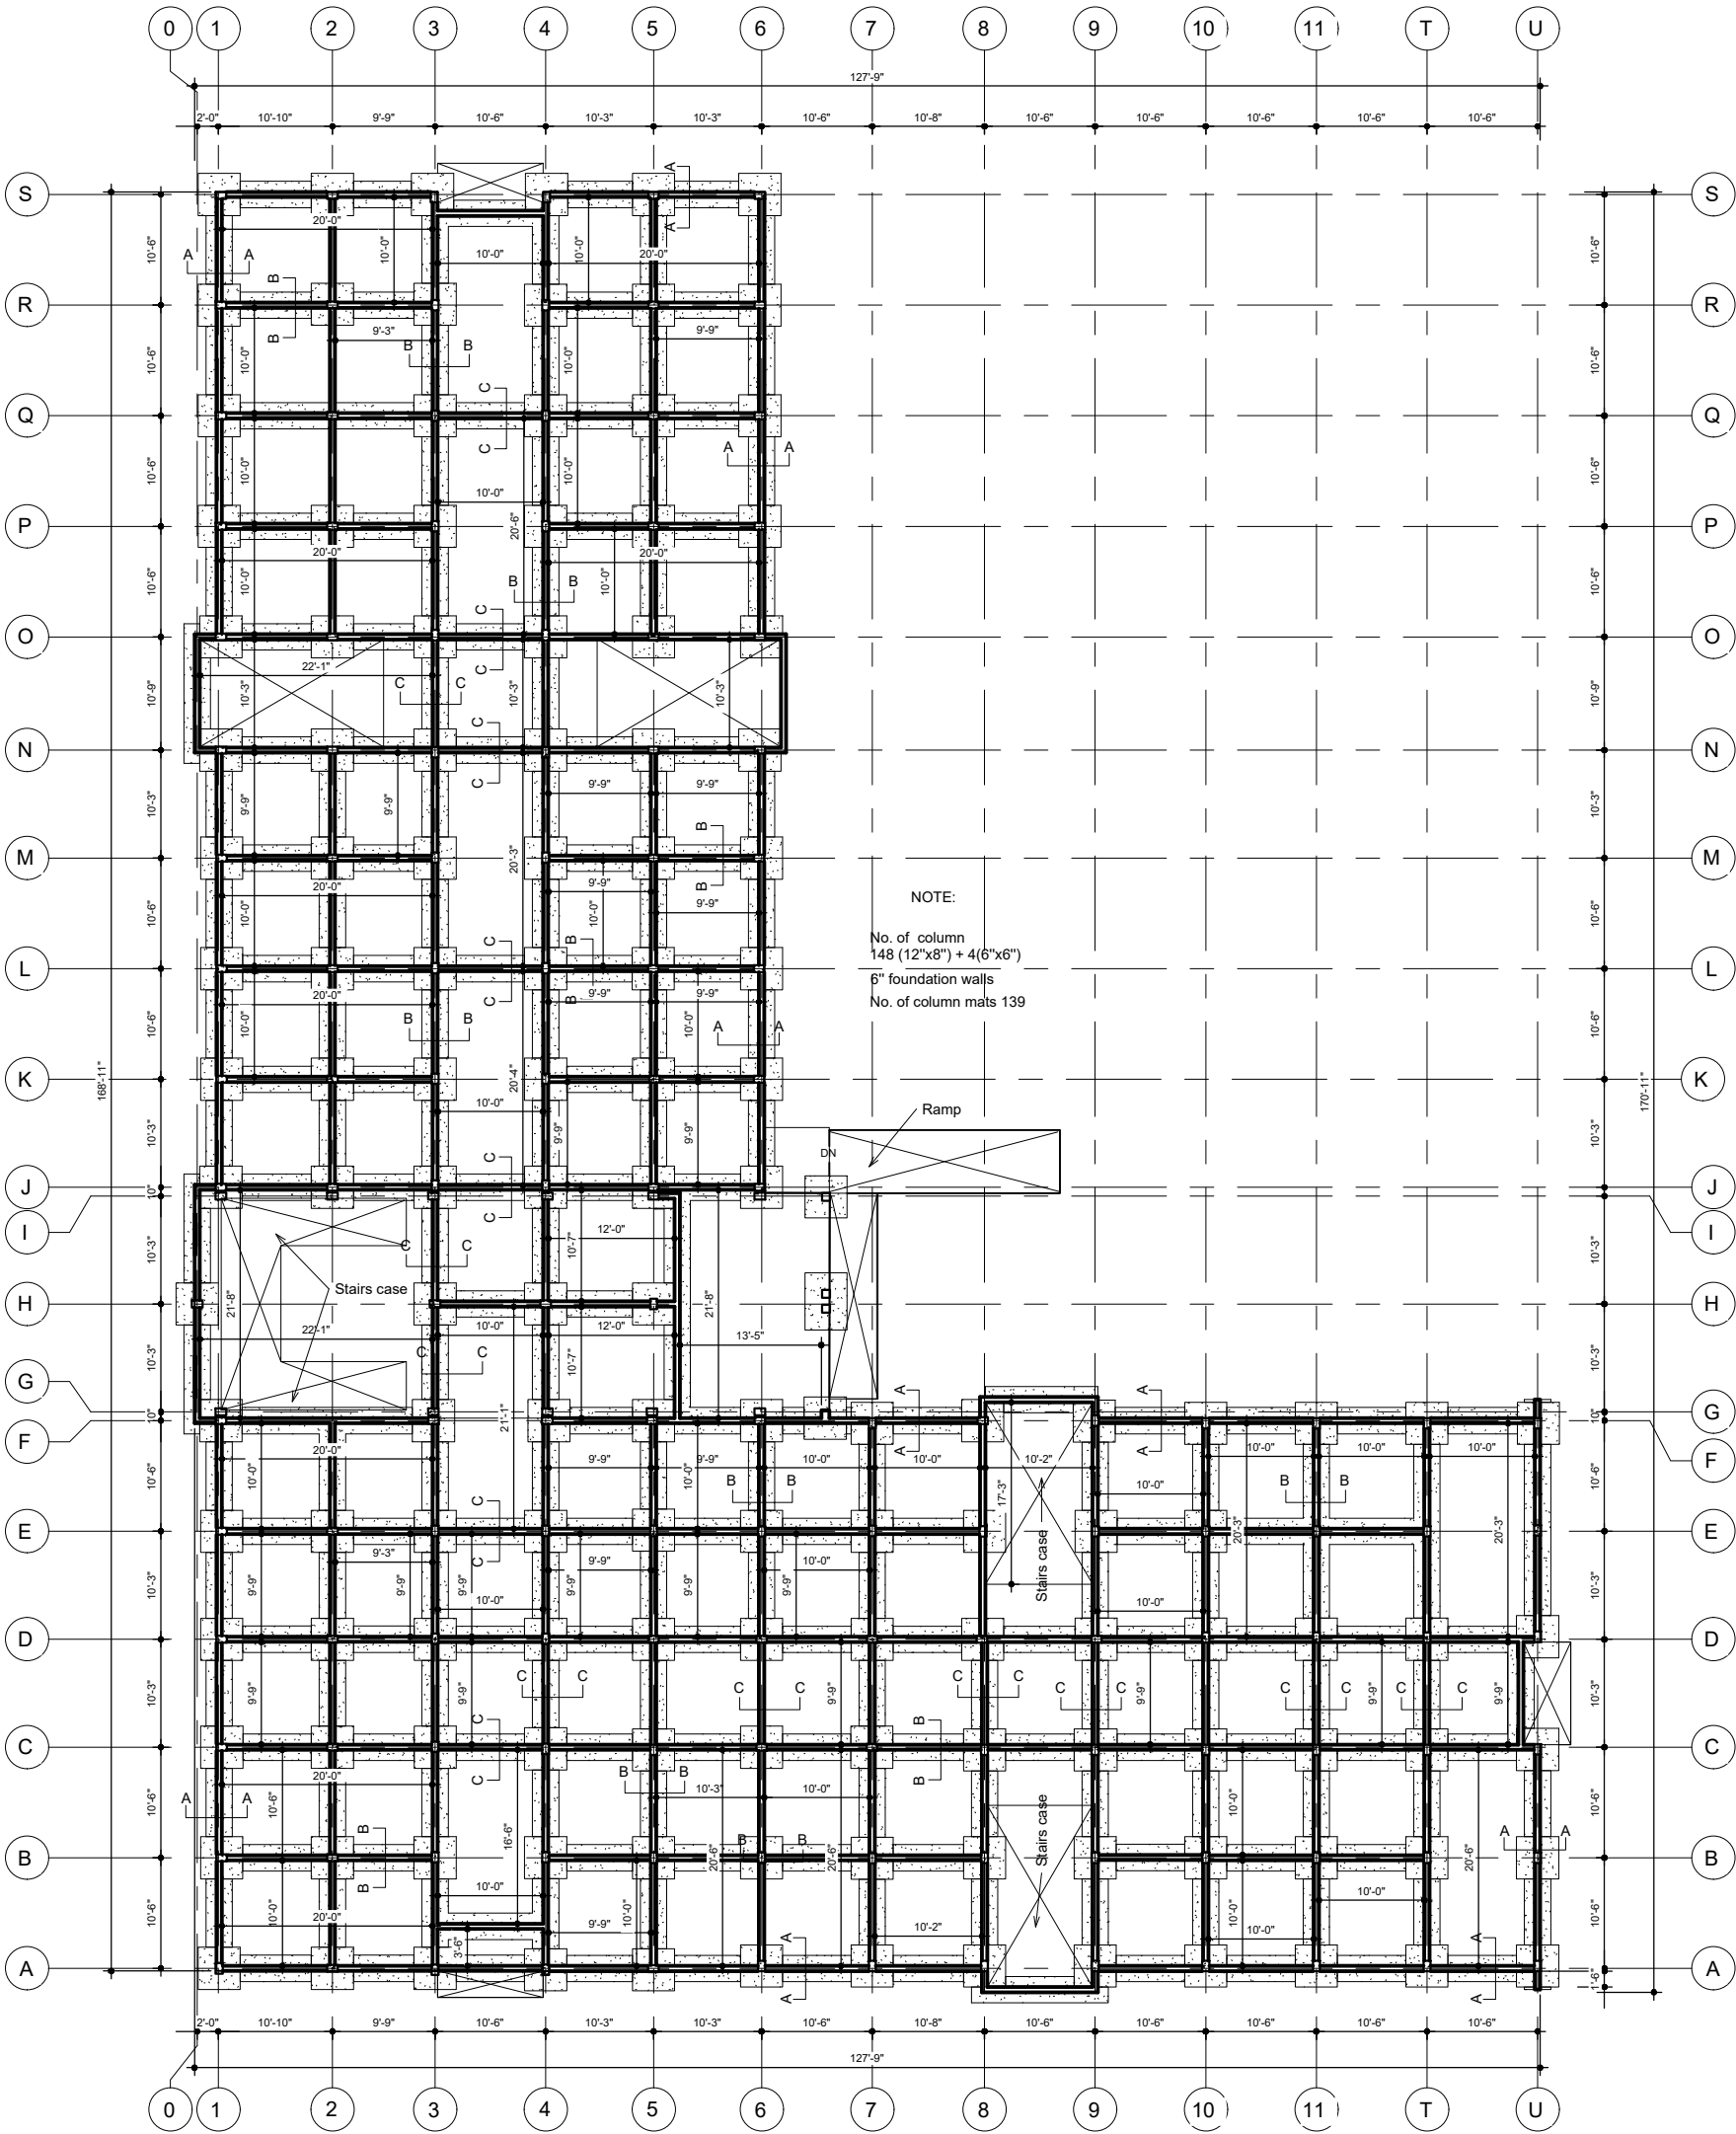

FOUNDATION PLAN

 LACCE LIBERIA ARCHITECTURAL CONSULTANCY & CONSTRUCTION ENGINEERING INC.	Location: N/A	Owner: N/A	STRUCTURAL DRAWING			
			Project number 0001	Date APRIL 6, 2026	Drawn by JOE R. SACKIE	Checker Scale
Notes		Project: MINISTRY COMPLEX		S-001		